

REFLECTED CEILING PLAN


[IGMH - K.MALE]
SCALE 1:100

CEILING FINISHES LEGEND		
CODE	SYMBOL	SPECIFICATION
CF-01		6MM TK GYPSUM BOARD SUSPENDED CEILING, FINISHED IN WHITE SATIN FINISH

LIGHTING & SWITCHING LEGEND

SYMBOL	DESCRIPTION
	CEILING MOUNT, WHITE, DOWNLIGHT
	1WAY-DOUBLE-GANG SWITCH

NOTE: ALL SWITCHES TO BE PLACED AT 1200 MM ABOVE FINISHED FLOOR UNLESS OTHERWISE SPECIFIED

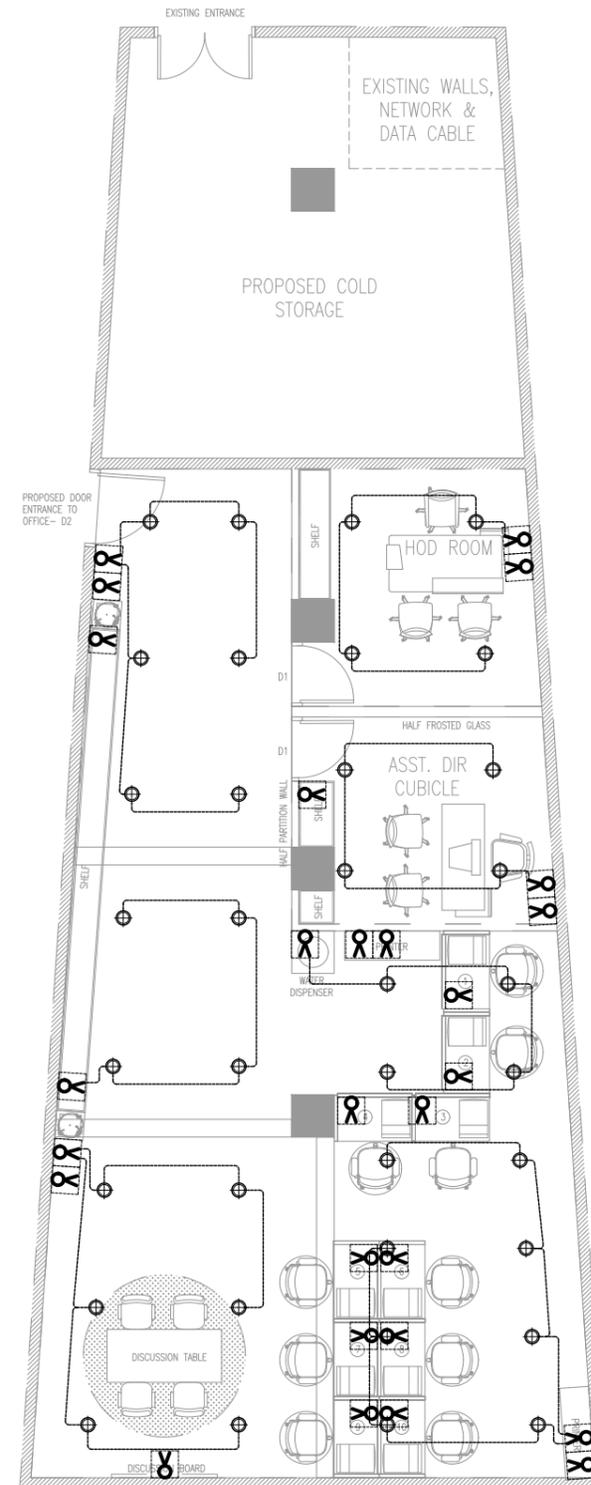

LIGHTING & SWITCHING PLAN

[IGMH - K.MALE]
SCALE 1:100

OWNER :
IGMH

KEY PLAN :

NOTES :

- THIS DRAWING SHALL NOT BE USED FOR CONSTRUCTION UNLESS CERTIFIED.
- CONTRACTOR TO VERIFY ALL DIMENSIONS OF EXISTING SITE BEFORE COMMENCING ANY WORK OR PREPARING SHOP DRAWINGS. DO NOT SCALE DRAWINGS, USE WRITTEN DIMENSIONS ONLY.
- THIS DRAWING IS TO BE READ IN CONJUNCTION WITH THE SPECIFICATIONS AND CONDITIONS OF CONTRACT.
- THIS DRAWING AND DESIGN IS COPYRIGHT AND NO PORTION MAY BE REPRODUCED WITHOUT THE PERMISSION OF THE CONSULTANT.

NO.	REVISION	DATE

PROJECT :
IGMH
K. MALE'

DISCIPLINE :

- ARCHITECTURAL DESIGN
- STRUCTURAL DESIGN
- INTERIOR DESIGN
- SERVICES DESIGN

PHASE :

- CONCEPTUAL DESIGN
- DESIGN DEVELOPMENT
- BUILDING APPROVAL
- CONSTRUCTION DOCUMENTATION
- AS-BUILT DRAWINGS

DESIGNATION	NAME
DESIGNER	INSIDE PLUS
ARCHITECT	
ENGINEER	
ARCH. CHECKER	
STRU. CHECKER	

INSIDE+
Interior Architecture & Design
H.Thevelli (7th Floor) . Kalaafaanu Hirigun . Male' . Maldives


info@inside-plus.com
www.inside-plus.com
+960 333 7587

CONTENTS :
AS GIVEN

CODE :	SHEET NO. :	REVISION :
EL - 01 - 0		

SCALE :	AS GIVEN	DATE :	06 APR 2025
FORMAT :	A3	ISSUE DATE :	

FILE NAME :

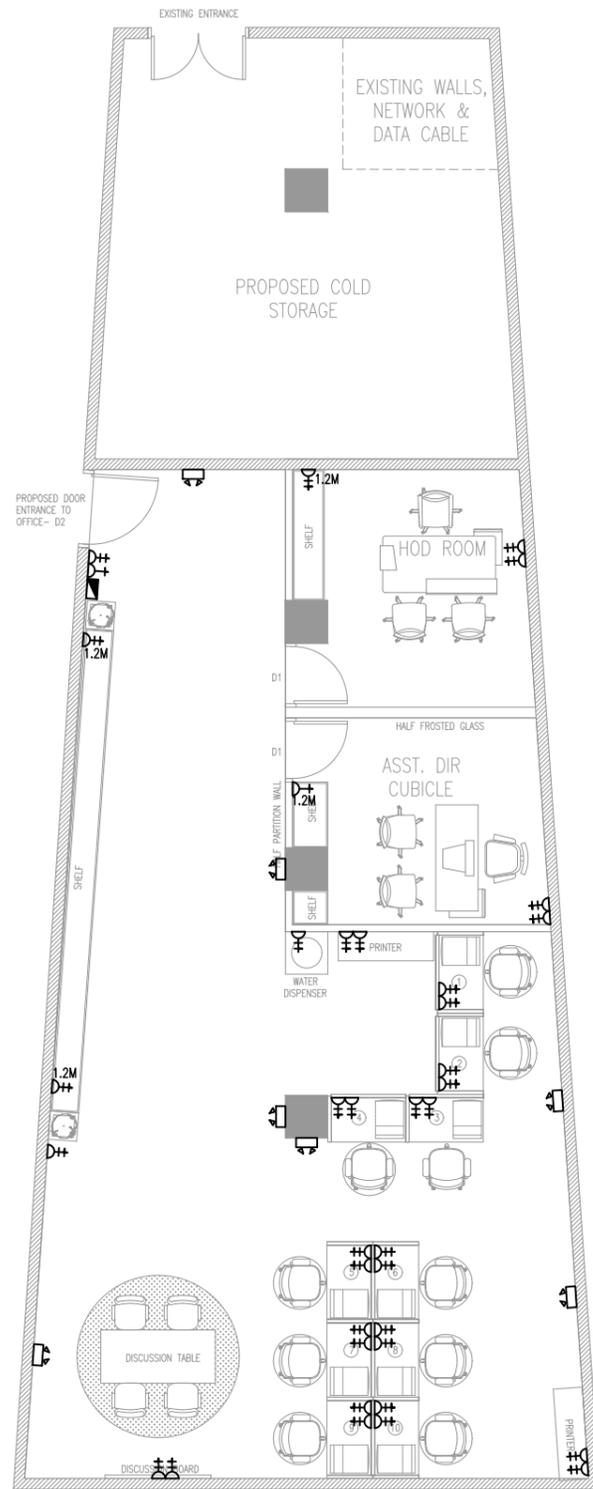


POWER LAYOUT
[IGMH - K.MALE]
SCALE 1:100

POWER LEGEND

SYMBOL	DESCRIPTION
	DISTRIBUTION BOARD (SINGLE/3 PHASE)
	EMERGENCY LIGHT-2HRS NON MAINTAINED
	2X13A SOCKET OUTLET (WALL MOUNTED)

NOTE:
ALL SWITCHES TO BE PLACED AT 1200 MM ABOVE FINISHED FLOOR UNLESS OTHERWISE SPECIFIED

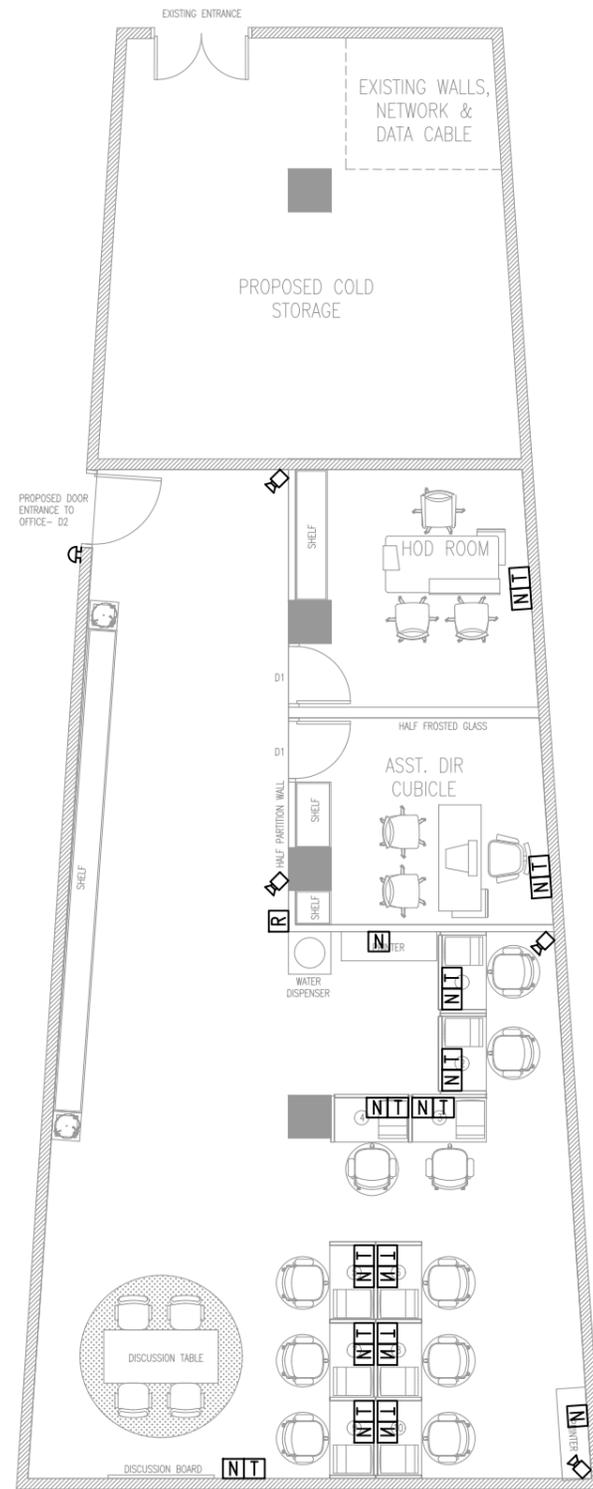

NETWORK LAYOUT
[IGMH - K.MALE]
SCALE 1:100

LEGEND

SYMBOL	DESCRIPTION
	DOOR ACCESS LOCK SYSTEM
	ROUTER
	NETWORK CAT6 CABLE OUTLET
	TELEPHONE OUTLET
	IR FIXED BULLET NETWORK CAMERA 4MP 3.6MM

OWNER :
IGMH

KEY PLAN :

NOTES :

- THIS DRAWING SHALL NOT BE USED FOR CONSTRUCTION UNLESS CERTIFIED.
- CONTRACTOR TO VERIFY ALL DIMENSIONS OF EXISTING SITE BEFORE COMMENCING ANY WORK OR PREPARING SHOP DRAWINGS. DO NOT SCALE DRAWINGS, USE WRITTEN DIMENSIONS ONLY.
- THIS DRAWING IS TO BE READ IN CONJUNCTION WITH THE SPECIFICATIONS AND CONDITIONS OF CONTRACT.
- THIS DRAWING AND DESIGN IS COPYRIGHT AND NO PORTION MAY BE REPRODUCED WITHOUT THE PERMISSION OF THE CONSULTANT.

NO.	REVISION	DATE

PROJECT :
IGMH
K. MALE'

- DISCIPLINE :
- ARCHITECTURAL DESIGN
 - STRUCTURAL DESIGN
 - INTERIOR DESIGN
 - SERVICES DESIGN

- PHASE :
- CONCEPTUAL DESIGN
 - DESIGN DEVELOPMENT
 - BUILDING APPROVAL
 - CONSTRUCTION DOCUMENTATION
 - AS-BUILT DRAWINGS

DESIGNATION	NAME
DESIGNER	INSIDE PLUS
ARCHITECT	
ENGINEER	
ARCH. CHECKER	
STRU. CHECKER	

INSIDE+
Interior Architecture & Design
H.Theveli (7th Floor) , Kalaafaanu Hir'gun , Male' , Maldives
info@inside-plus.com
www.inside-plus.com
+960 333 7587

CONTENTS :
AS GIVEN

CODE : SHEET NO. : REVISION :
EL - 01 - 0

SCALE :	AS GIVEN	DATE :	06 APR 2025
FORMAT :	A3	ISSUE DATE :	
FILE NAME :			

OWNER :
IGMH

KEY PLAN :

NOTES :

- THIS DRAWING SHALL NOT BE USED FOR CONSTRUCTION UNLESS CERTIFIED.
- CONTRACTOR TO VERIFY ALL DIMENSIONS OF EXISTING SITE BEFORE COMMENCING ANY WORK OR PREPARING SHOP DRAWINGS. DO NOT SCALE DRAWINGS, USE WRITTEN DIMENSIONS ONLY.
- THIS DRAWING IS TO BE READ IN CONJUNCTION WITH THE SPECIFICATIONS AND CONDITIONS OF CONTRACT.
- THIS DRAWING AND DESIGN IS COPYRIGHT AND NO PORTION MAY BE REPRODUCED WITHOUT THE PERMISSION OF THE CONSULTANT.

NO.	REVISION	DATE

PROJECT :
IGMH
K. MALE'

- DISCIPLINE :
- ARCHITECTURAL DESIGN
 - STRUCTURAL DESIGN
 - INTERIOR DESIGN
 - SERVICES DESIGN

- PHASE :
- CONCEPTUAL DESIGN
 - DESIGN DEVELOPMENT
 - BUILDING APPROVAL
 - CONSTRUCTION DOCUMENTATION
 - AS-BUILT DRAWINGS


DESIGNATION	NAME
DESIGNER	INSIDE PLUS
ARCHITECT	
ENGINEER	
ARCH. CHECKER	
STRU. CHECKER	

INSIDE+
Interior Architecture & Design
H.Theveli (7th Floor) . Kalaafaanu Hir'gun . Male' . Maldives
 info@inside-plus.com
 www.inside-plus.com
 +960 333 7587

CONTENTS :
AS GIVEN


CODE : SHEET NO. : REVISION :
EL - 01 - 0

SCALE :	AS GIVEN	DATE :	06 APR 2025
FORMAT :	A3	ISSUE DATE :	
FILE NAME :			

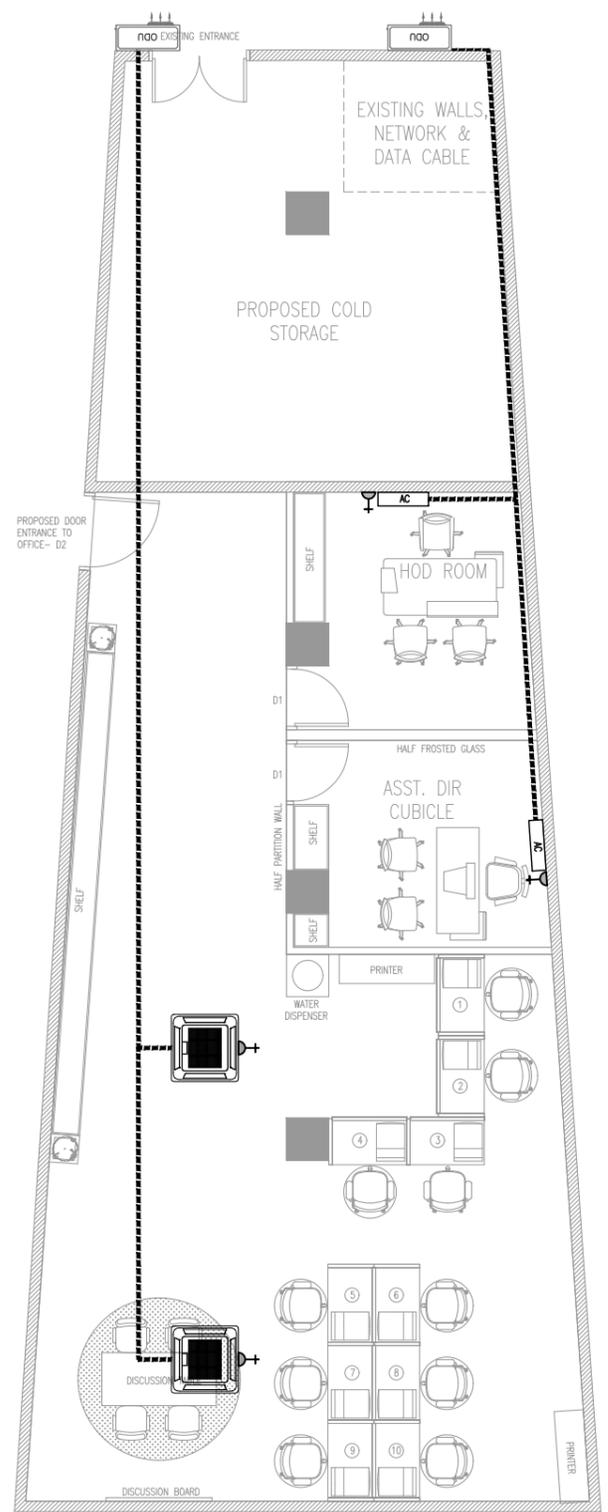


AC LEGEND

SYMBOL	DESCRIPTION
	CASSETTE AC INDOOR UNIT
	12000/9000 BTU WALL MOUNT SPLIT INDOOR UNIT
	SINGLE/MULTI OUTDOOR UNIT
	AC UNIT INLET/OUTLET & DRAIN PIPE
	2.1M LVL WALL MOUNTED SOCKET
	ROOF MOUNTED SOCKET

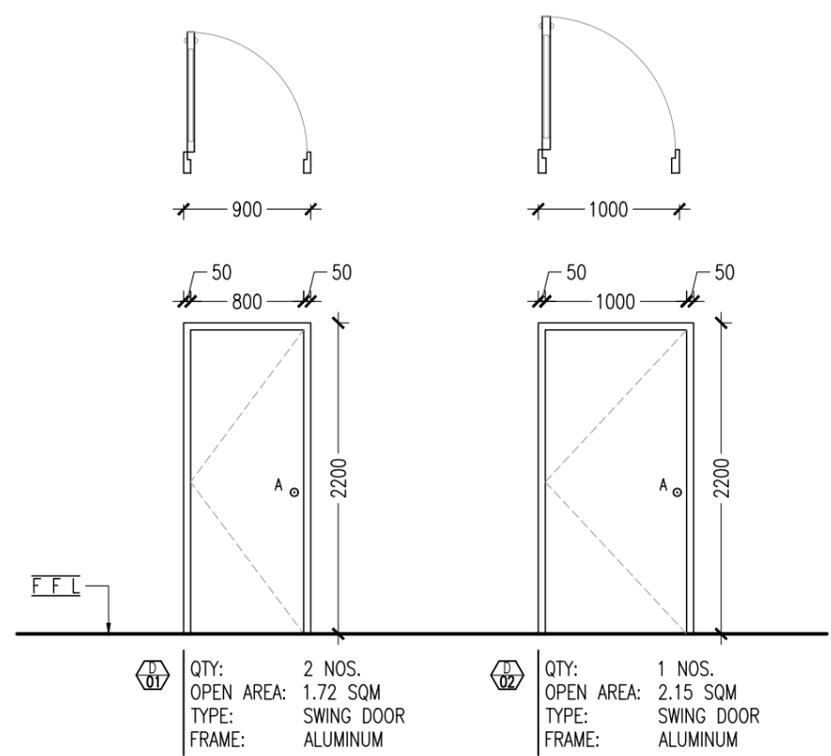

AC LAYOUT
[IGMH - K.MALE]
SCALE 1:100

DOOR SCHEDULE
[IGMH - K.MALE]
SCALE 1:100

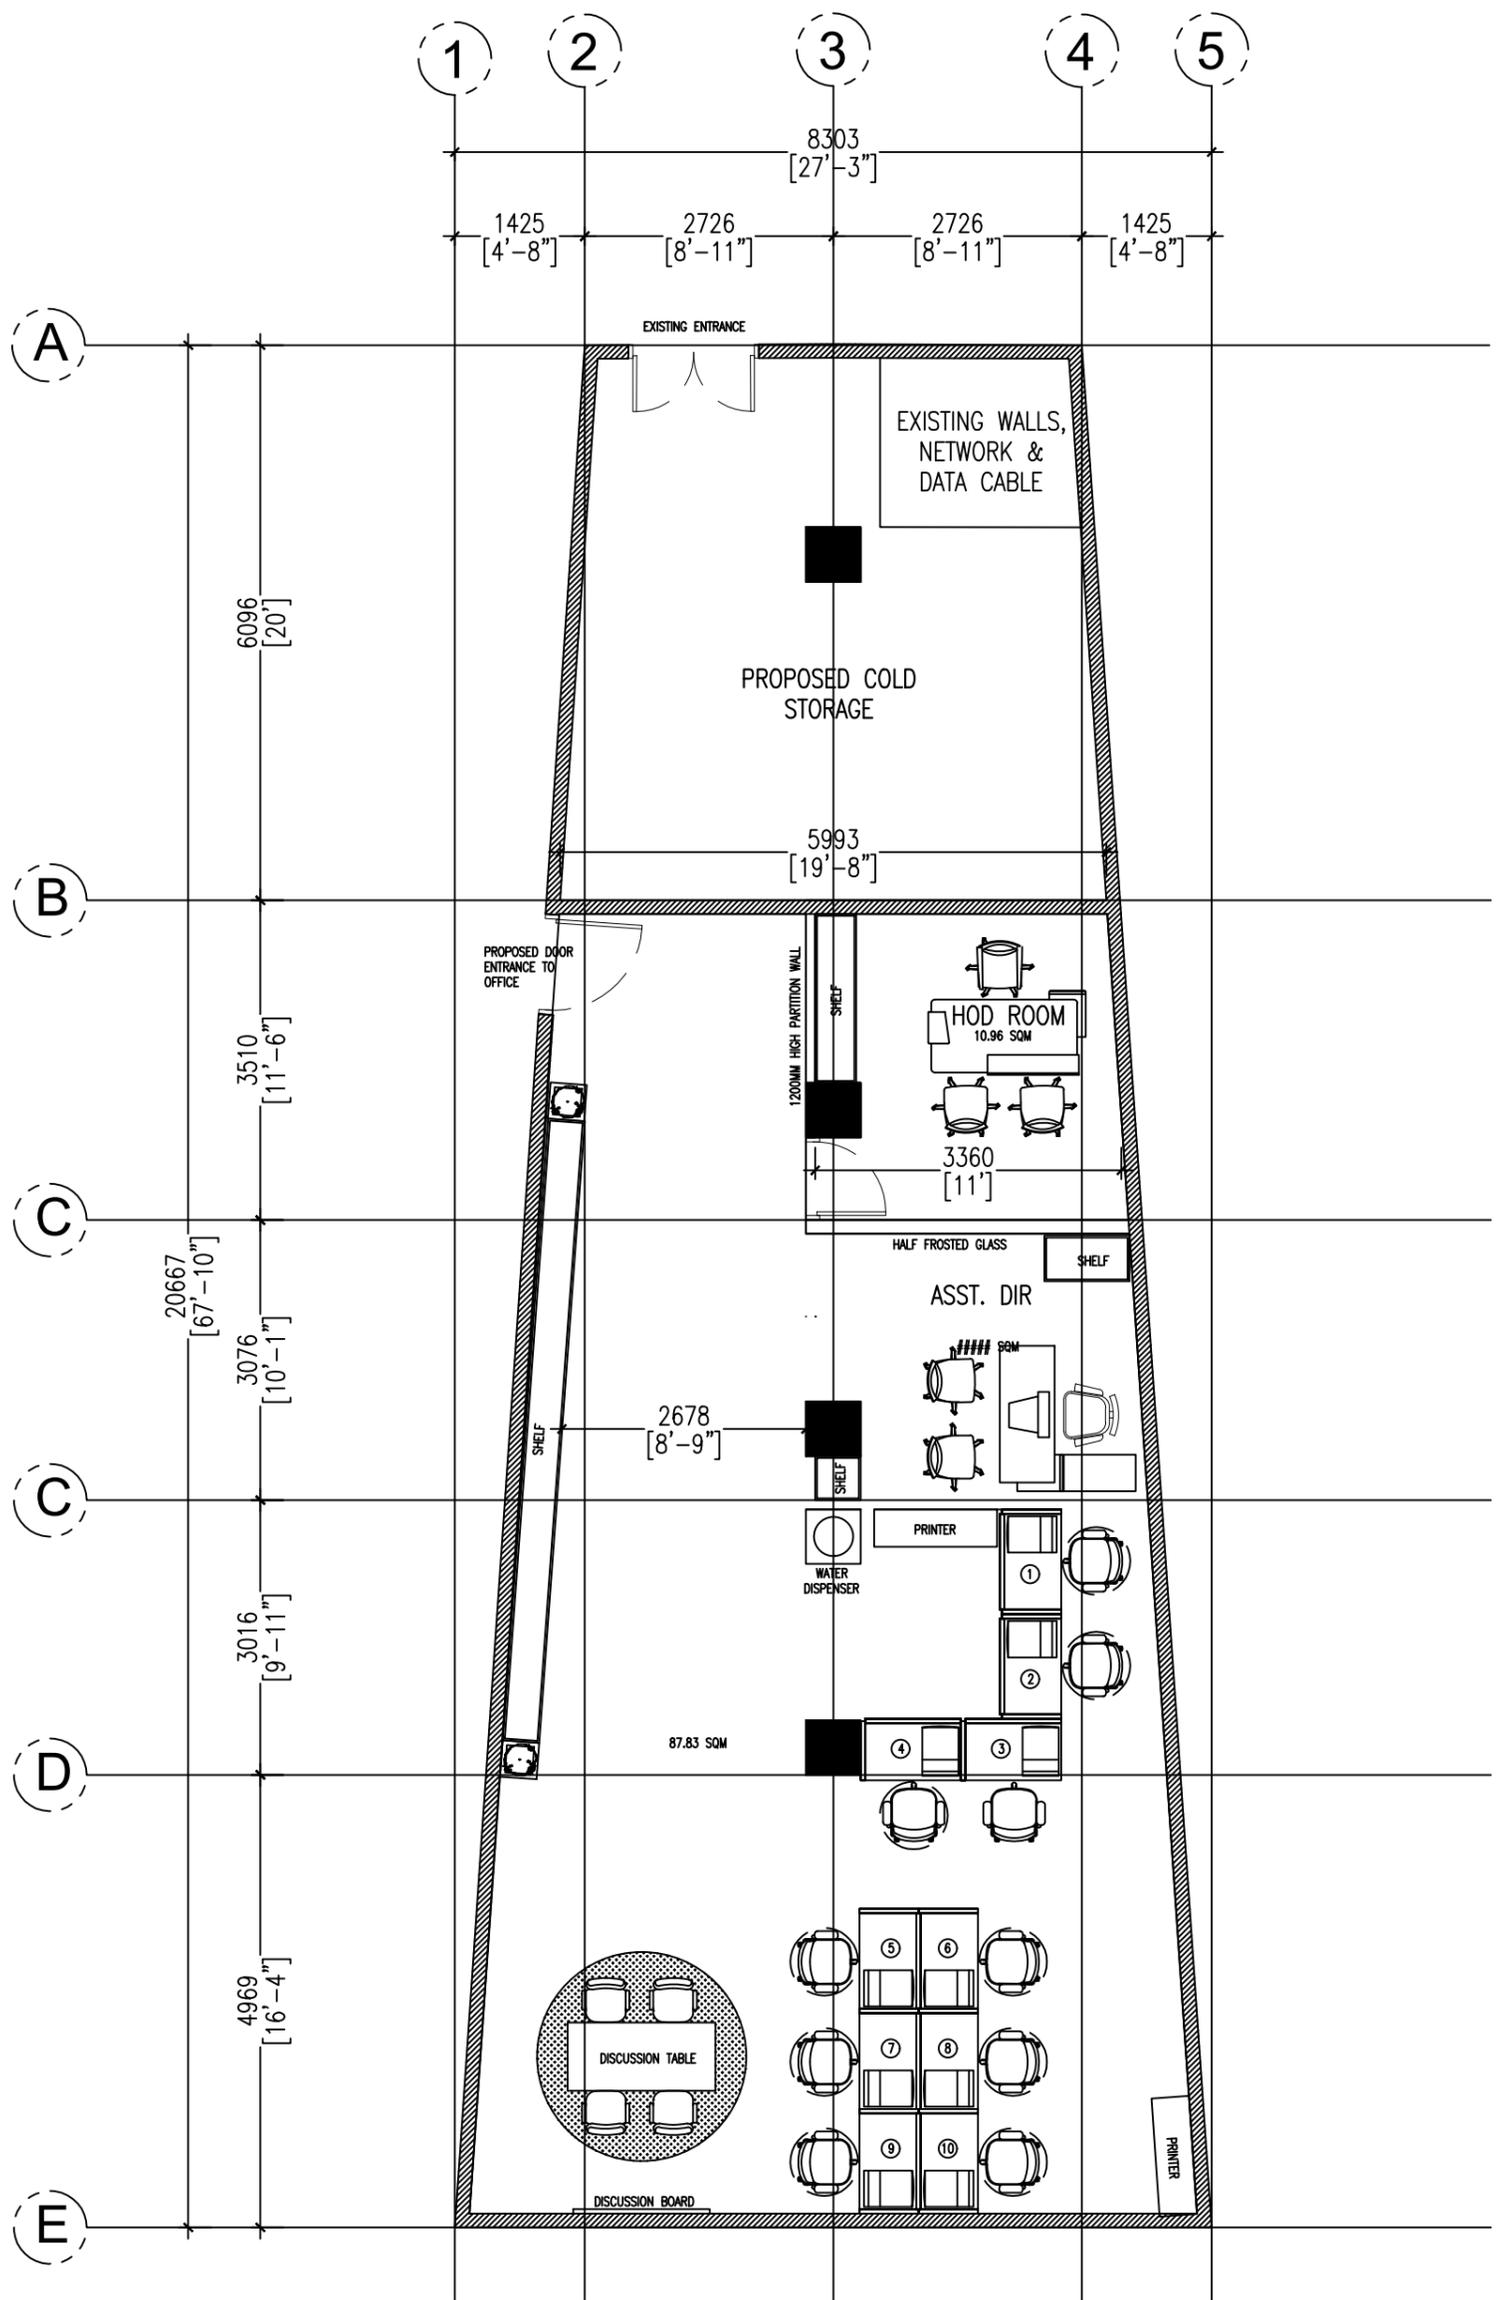

IGMH-PROPOSED OFFICE

[IGMH - K.MALE]
SCALE 1:100